

Tarpon Prospect - Well 1
 Lat = 29°31'35.44" N (NAD83)
 Lon = 94°34'17.48" W (NAD83)
 X = 3,408,037 (NAD27)
 Y = 642,200 (NAD27)

Tarpon Prospect - Well 2
 Lat = 29°31'34.72" N (NAD83)
 Lon = 94°34'17.72" W (NAD83)
 X = 3,408,018 (NAD27)
 Y = 642,128 (NAD27)



Scale: 1" = 3,500'

Legend

★ - Proposed Well Locations

Reference

Base map comprised of USGS Topo Map for Frozen Point, TX

**Vicinity Map
 Tarpon Prospects**


Galveston County, Texas

Hilcorp Energy Company



Drawn By	JJS	11/1/2018
Checked By	TJ	9/25/18
Approved By	RS	9/25/18

Project Number 1140-042	1 Figure
Drawing Number 1140-042-A002	

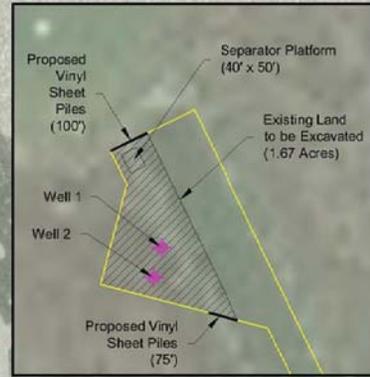

Inset
Scale: 1" = 300'



Legend

 
Spoil Placement Areas (29.43 Acres)

Notes

1. Quantities calculated using survey conducted on 05-30&31-2013.
2. Water Line at time of survey was +1.3'
3. Calculations based on 70' wide and draft from elevation +1.3'

Reference

Base map comprised of Bing Maps aerial imagery from (c) 2018 Microsoft Corporation and its data suppliers.



Access Site Plan

Tarpon Prospect
Galveston County, Texas



Hilcorp Energy Company
Tarpon Prospect



Drawn By	LMH	11/01/18
Checked By	LMH	11/01/18
Approved By	RS	11/01/18

Project Number	1140-042
Drawing Number	1140-042-B002

2
Figure

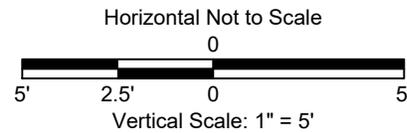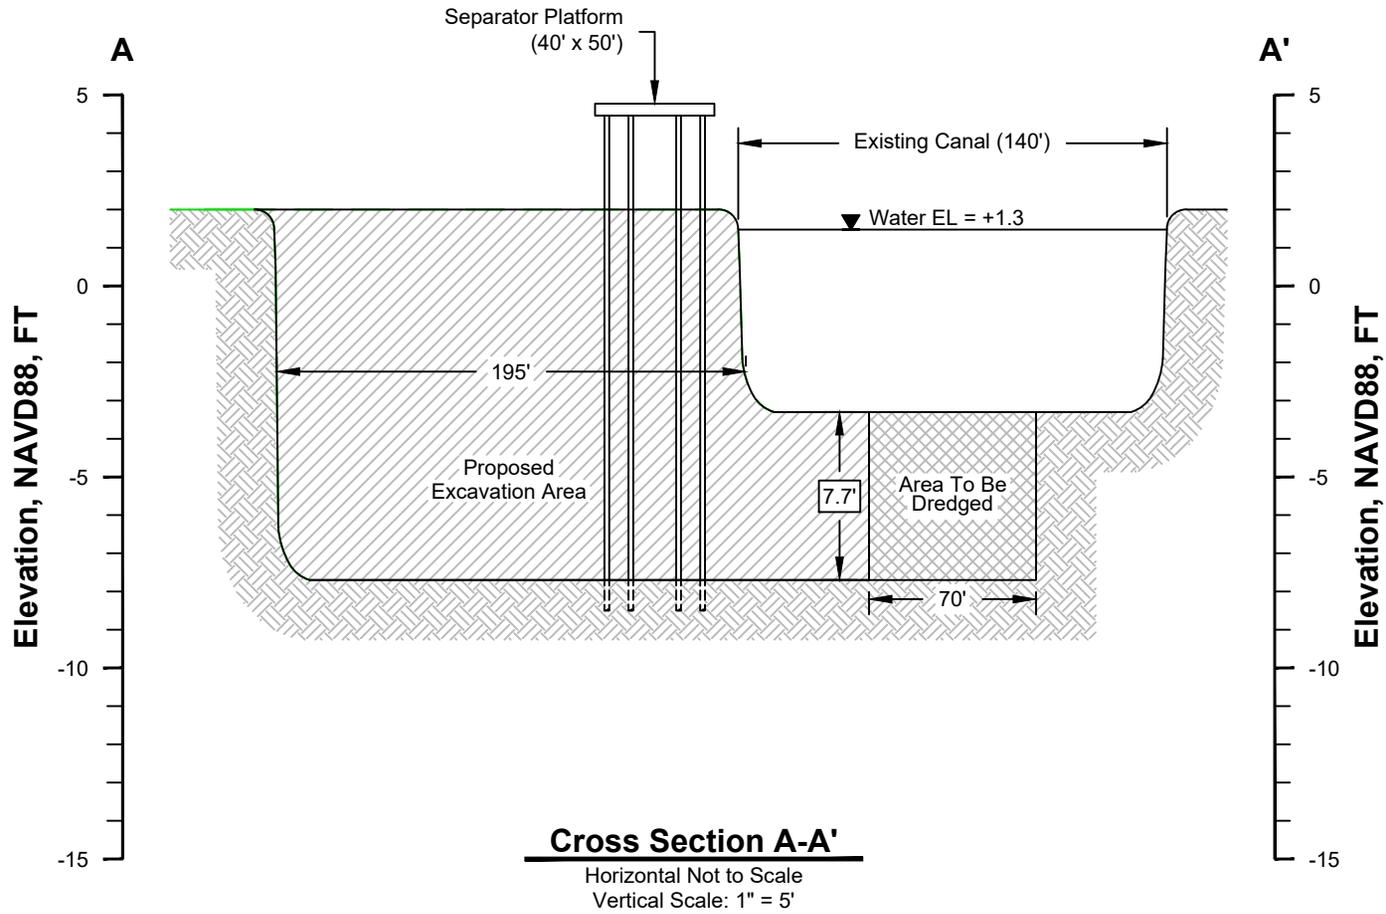

Cross Section A-A'

Tarpon Prospects
Galveston County, Texas

Hilcorp Energy Company
Tarpon Prospects





Drawn By	LMM	10/30/18
Checked By	RS	10/30/18
Approved By	RS	10/30/18

Project Number
1140-042

Drawing Number
1140-042-A005

3a
Figure

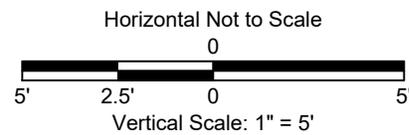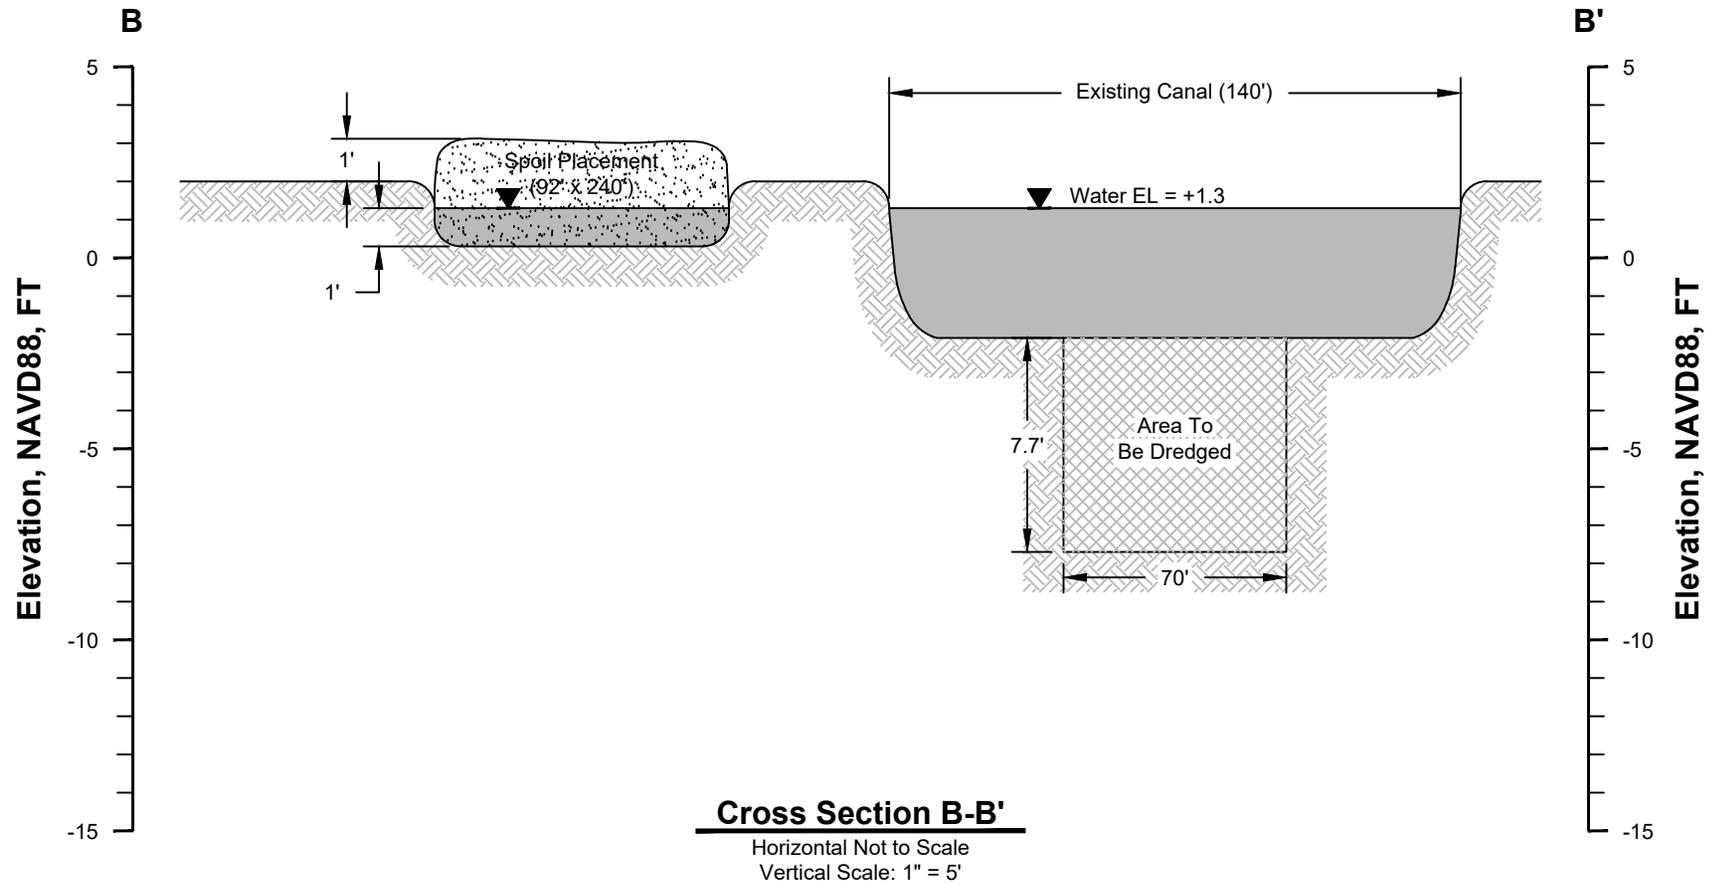

Cross Section B-B'

Tarpon Prospects
 Galveston County, Texas


Hilcorp Energy Company
 Tarpon Prospects




Drawn By	LMM	10/03/18
Checked By	RS	10/03/18
Approved By	RS	10/03/18

Project Number
 1140-042
 Drawing Number
 1140-042-A006

3b
 Figure

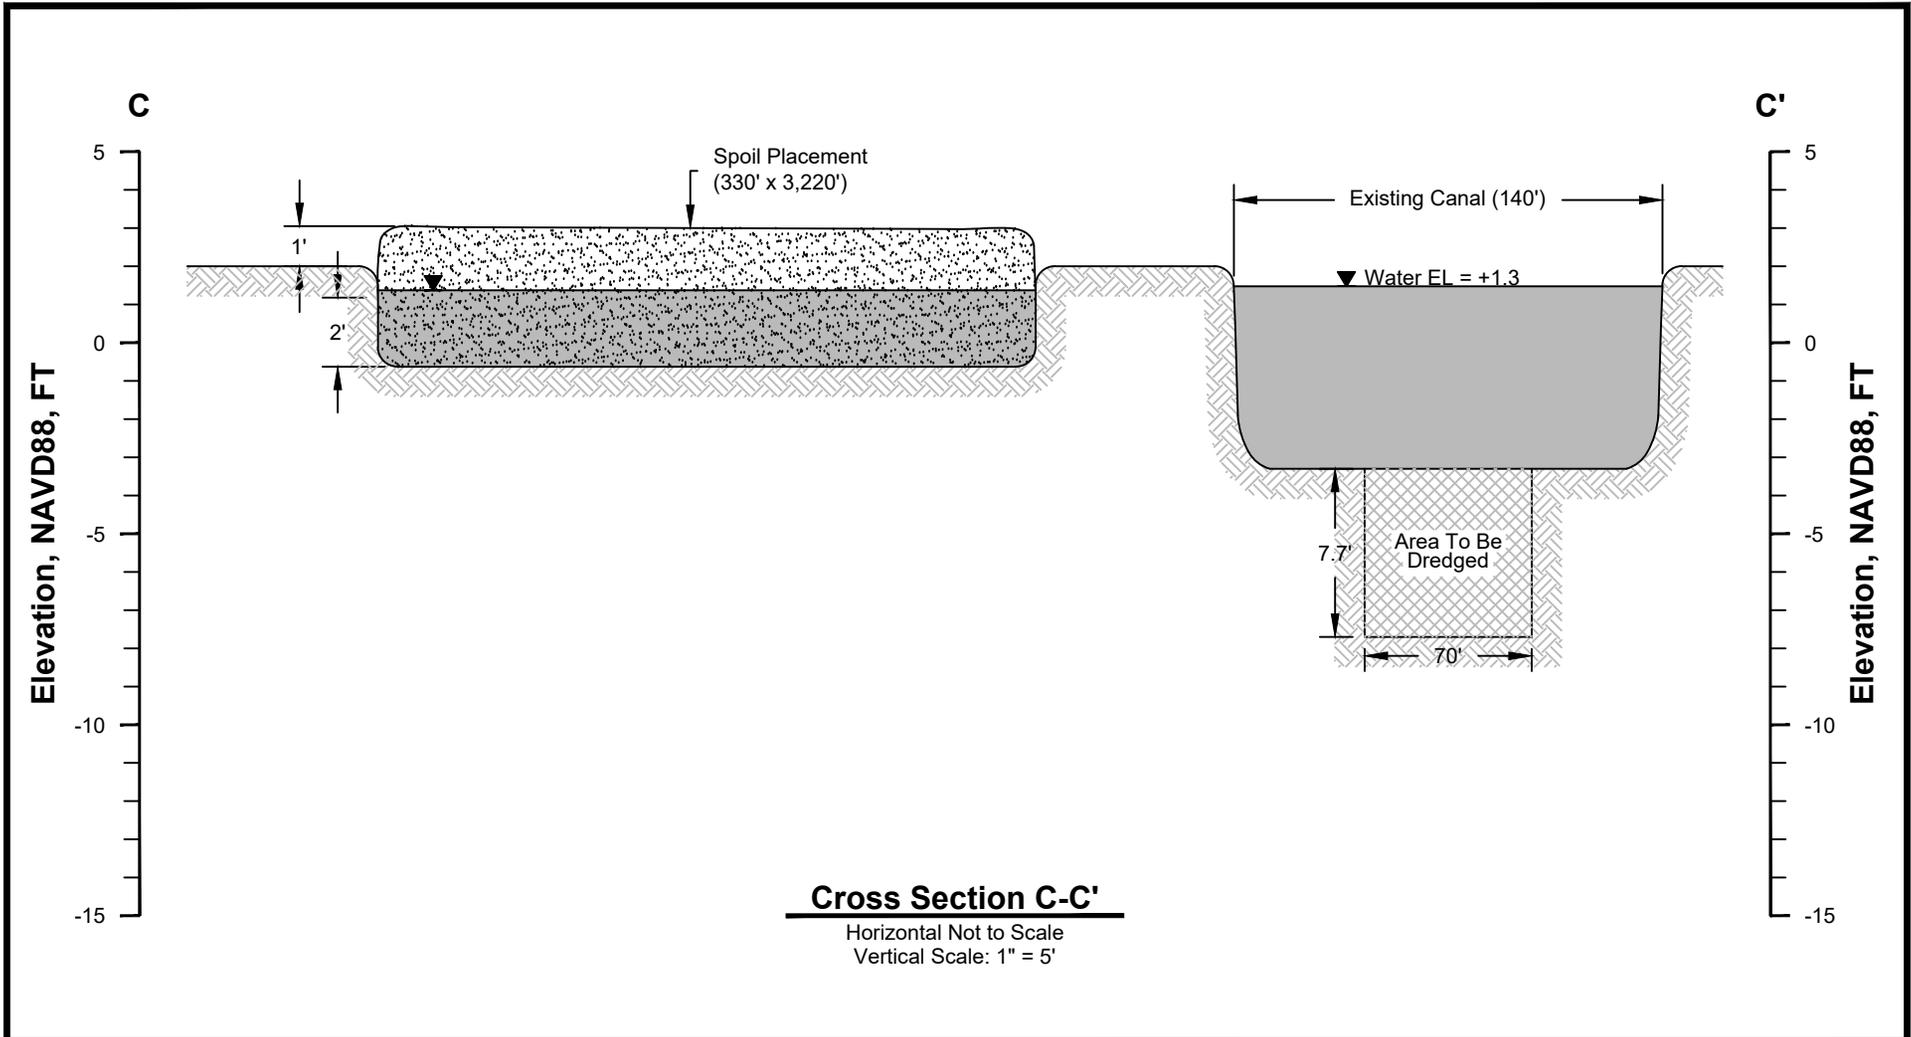

Cross Section C-C'
 Horizontal Not to Scale
 Vertical Scale: 1" = 5'

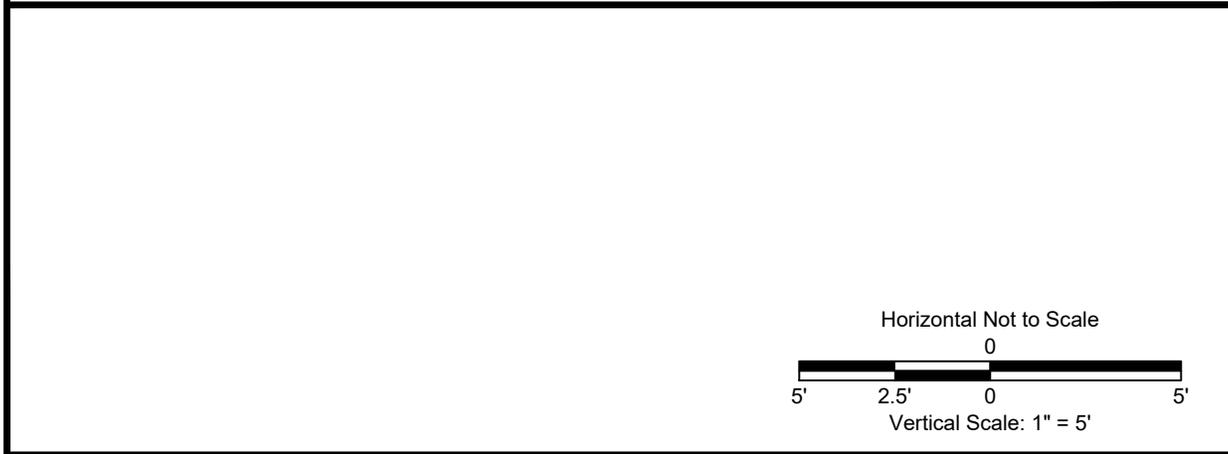


Cross Section C-C'


Tarpon Prospects
Galveston County, Texas

Hilcorp Energy Company
Tarpon Prospects

Drawn By	LMM	10/03/18
Checked By	RS	10/03/18
Approved By	RS	10/03/18
Project Number		3c Figure
1140-042		
Drawing Number		1140-042-A007

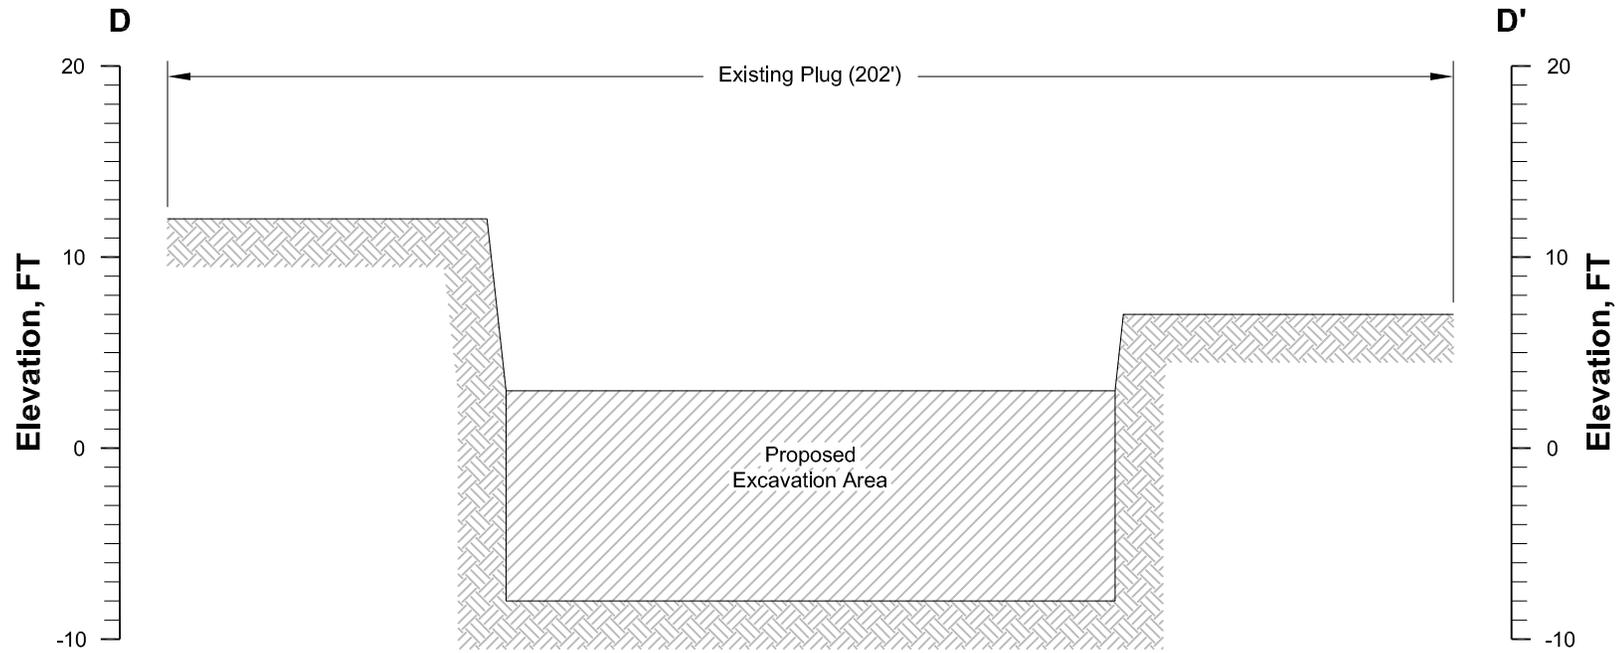

Section D-D'
 Horizontal Scale: 1" = 30'
 Vertical Scale: 1" = 10'

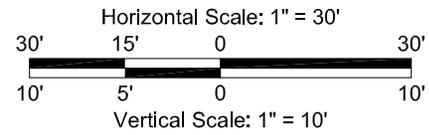

Cross Section D-D'

Tarpon Prospects
 Galveston County, Texas

Hilcorp Energy Company
 Tarpon Prospects




Drawn By	LMM	10/30/18
Checked By	RS	10/30/18
Approved By	RS	10/30/18


Project Number 1140-042
Drawing Number 1140-042-A008

3d
 Figure

Typical Diesel Powered Drill Barge

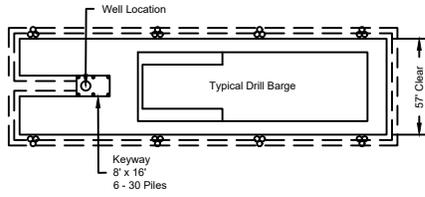

Plan
Not to Scale

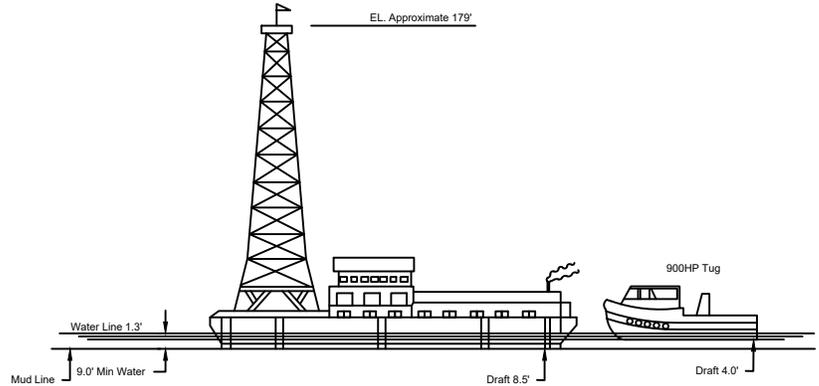


Elevation
Not to Scale


Note

8 temporary 3 pile clusters to be driven to assist in removing drill barge from location. Temporary clusters to be pulled when permanent well guard is installed.

Typical Well Head Protector

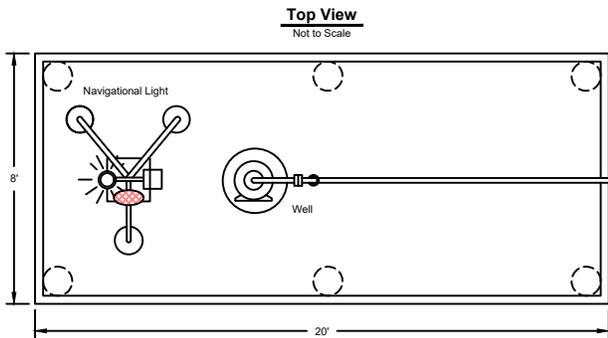

Top View
Not to Scale

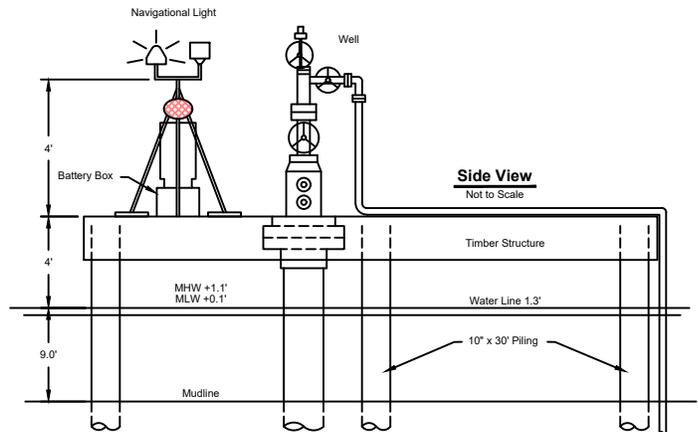

Side View
Not to Scale

Well Details

Tarpon Prospects
Galveston County, Texas

Hilcorp Energy Company
Tarpon Prospects



Drawn By	LMM	10/31/18
Checked By	OB	10/31/18
Approved By	RS	10/31/18

Project Number	4
1140-042	
Drawing Number	Figure
1140-042-A009	

Reference

Details comprised from client provided figure.