


TDC 07/08/98 13:14 F:\MARINER\H1359\A22PM900.DWG

GALVESTON AREA
GULF OF MEXICO
BLOCK 151
OCS-G15740
MARINER ENERGY INC.

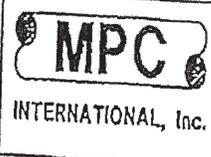


MARINER ENERGY INC.
6" PIPELINE FROM GA-151 CAISSON TO GA-151 TIE-IN

VICINITY MAP

DWG. FIG: A2-2-PM-900		
ORIGIN. DATE: 7/6/98	REV. DATE:	REV: A
SCALE: N.T.S.	PROJECT: H-1359	



5 mi

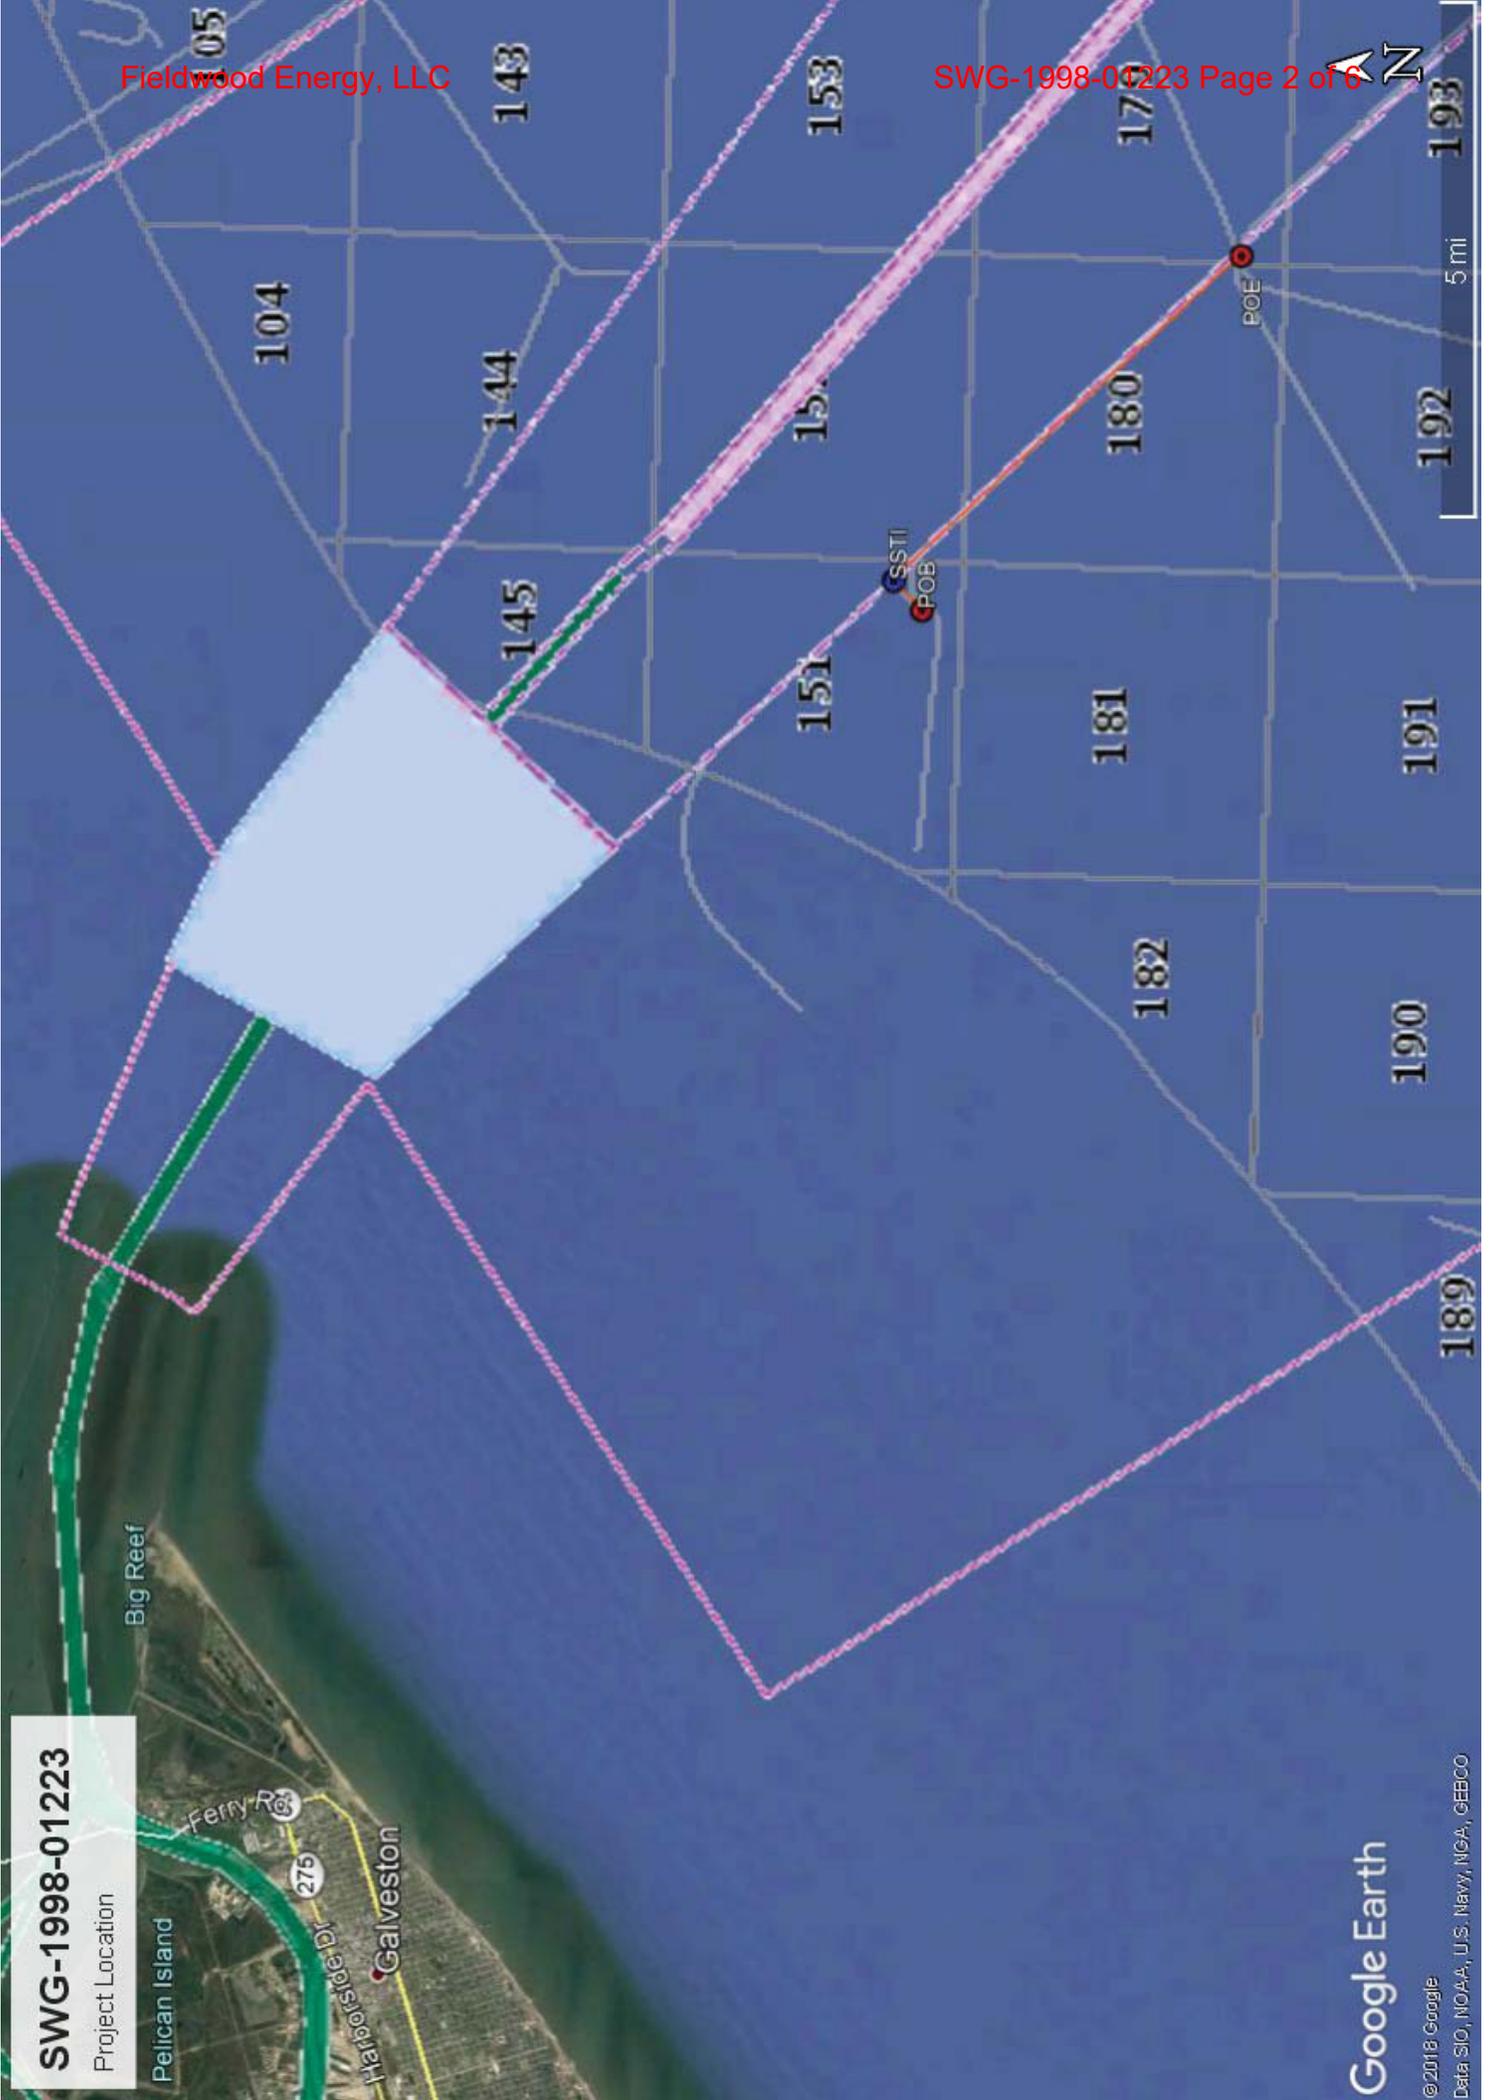

SWG-1998-01223


Project Location

Pelican Island

Ferry Rd

275



Galveston

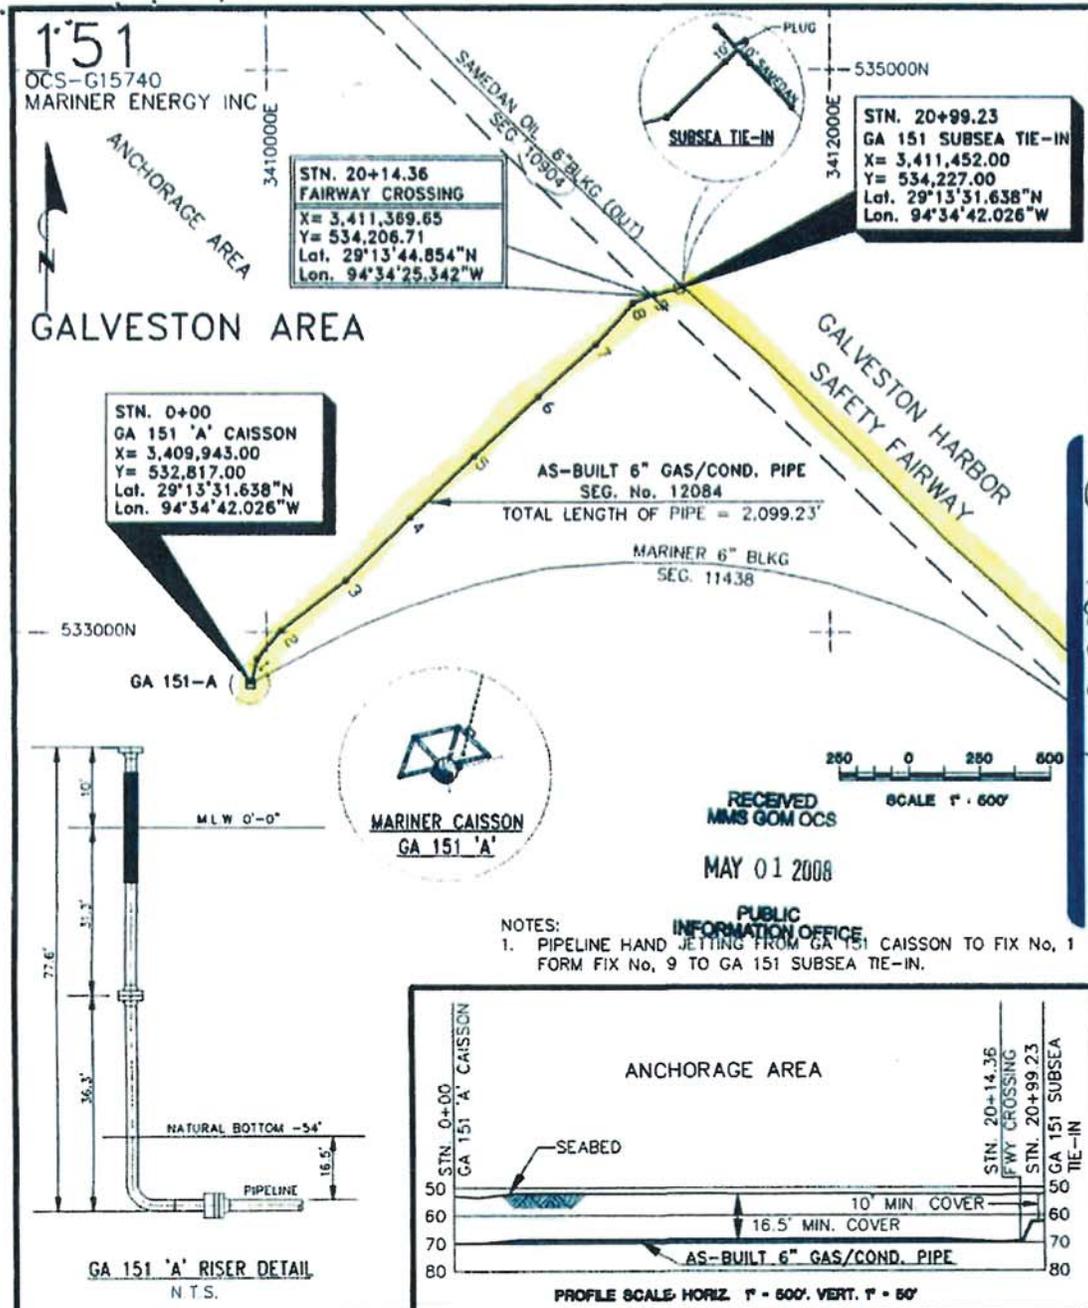

STN. 0+00
GA 151 'A' CAISSON
X = 3,409,943.00
Y = 532,817.00
Lat. 29°13'31.638"N
Lon. 94°34'42.026"W

STN. 20+14.36
FAIRWAY CROSSING
X = 3,411,369.65
Y = 534,206.71
Lat. 29°13'44.854"N
Lon. 94°34'25.342"W

STN. 20+99.23
GA 151 SUBSEA TIE-IN
X = 3,411,452.00
Y = 534,227.00
Lat. 29°13'31.638"N
Lon. 94°34'42.026"W

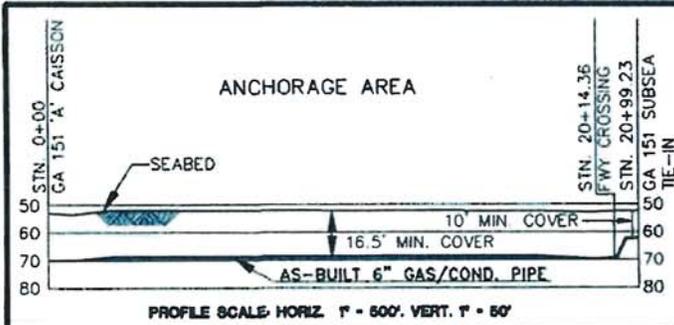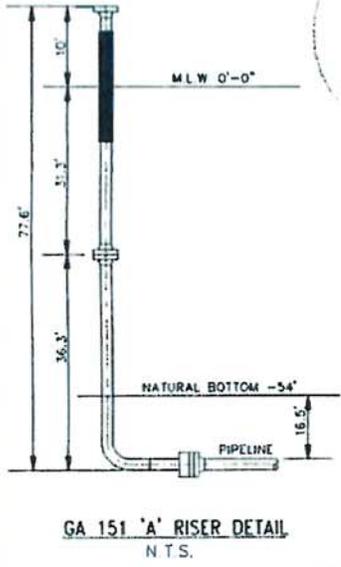

NOTES:
1. PIPELINE HAND JETTING FROM GA 151 CAISSON TO FIX No. 1 FORM FIX No. 9 TO GA 151 SUBSEA TIE-IN.

AS-BUILT 6" GAS/COND. PIPELINE FROM GA 151 'A' TO SSI

POINT	X COORD.	Y COORD.	POINT	X COORD.	Y COORD.
GA 151 CAISSON	3,409,943.00	532,817.00	6	3,410,966.65	533,843.08
1	3,409,965.00	532,905.00	7	3,411,169.40	534,031.17
2	3,410,049.00	533,006.00	8	3,411,302.03	534,181.05
3	3,410,277.95	533,184.56	9	3,411,375.76	534,209.03
4	3,410,505.48	533,408.03	FLG	3,411,452.00	534,227.00
5	3,410,736.62	533,627.09			

TOTAL FOOTAGE (excluding riser) = 2,099.23

I HEREBY CERTIFY THE ABOVE AS-BUILT PIPELINE LOCATION IS CORRECT

STATE OF TEXAS
COUNTY OF GALVESTON

Date: 11/04/99

DATUM: NAD 27
SPHEROID: CLARKE 1866
PROJECTION: LAMBERT
ZONE: TEXAS SOUTH CENTRAL



Racal NCS, Inc.
3624 Westchase Drive
Houston, Texas 77062
Tel. 713-784-4462 Fax: 713-784-8162

MARINER ENERGY INC. 3/18/04

AS-BUILT 6" GAS/COND. PIPELINE
SEGMENT No. 12084
GA 151 'A' TO SSI
GALVESTON AREA

DATE: 10/22/99	DRAWN BY: BAR	CHECKED BY:	DRAWING No. 5012084_3466
REV DATE: 11/04/99	REV No.: 01-ADD RISER	SCALE: AS-SHOWN	JOB No.: 1891 DP No.: 3466

12084

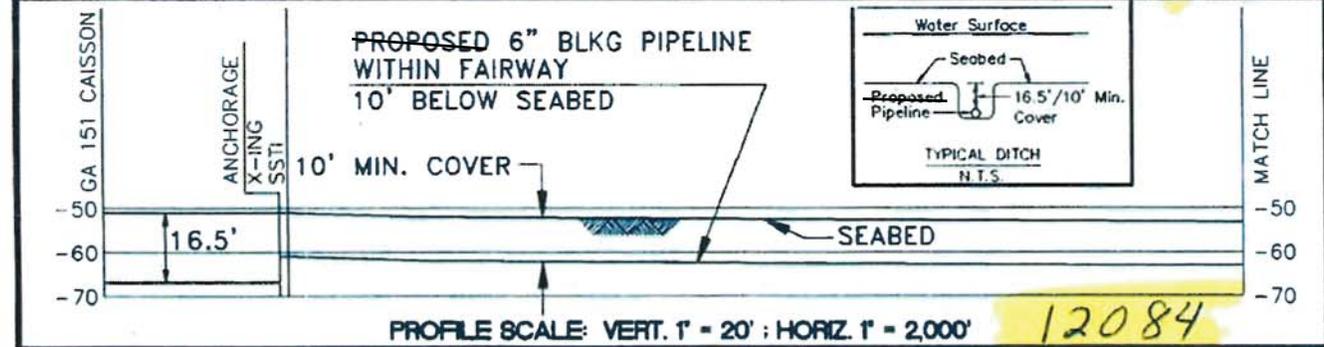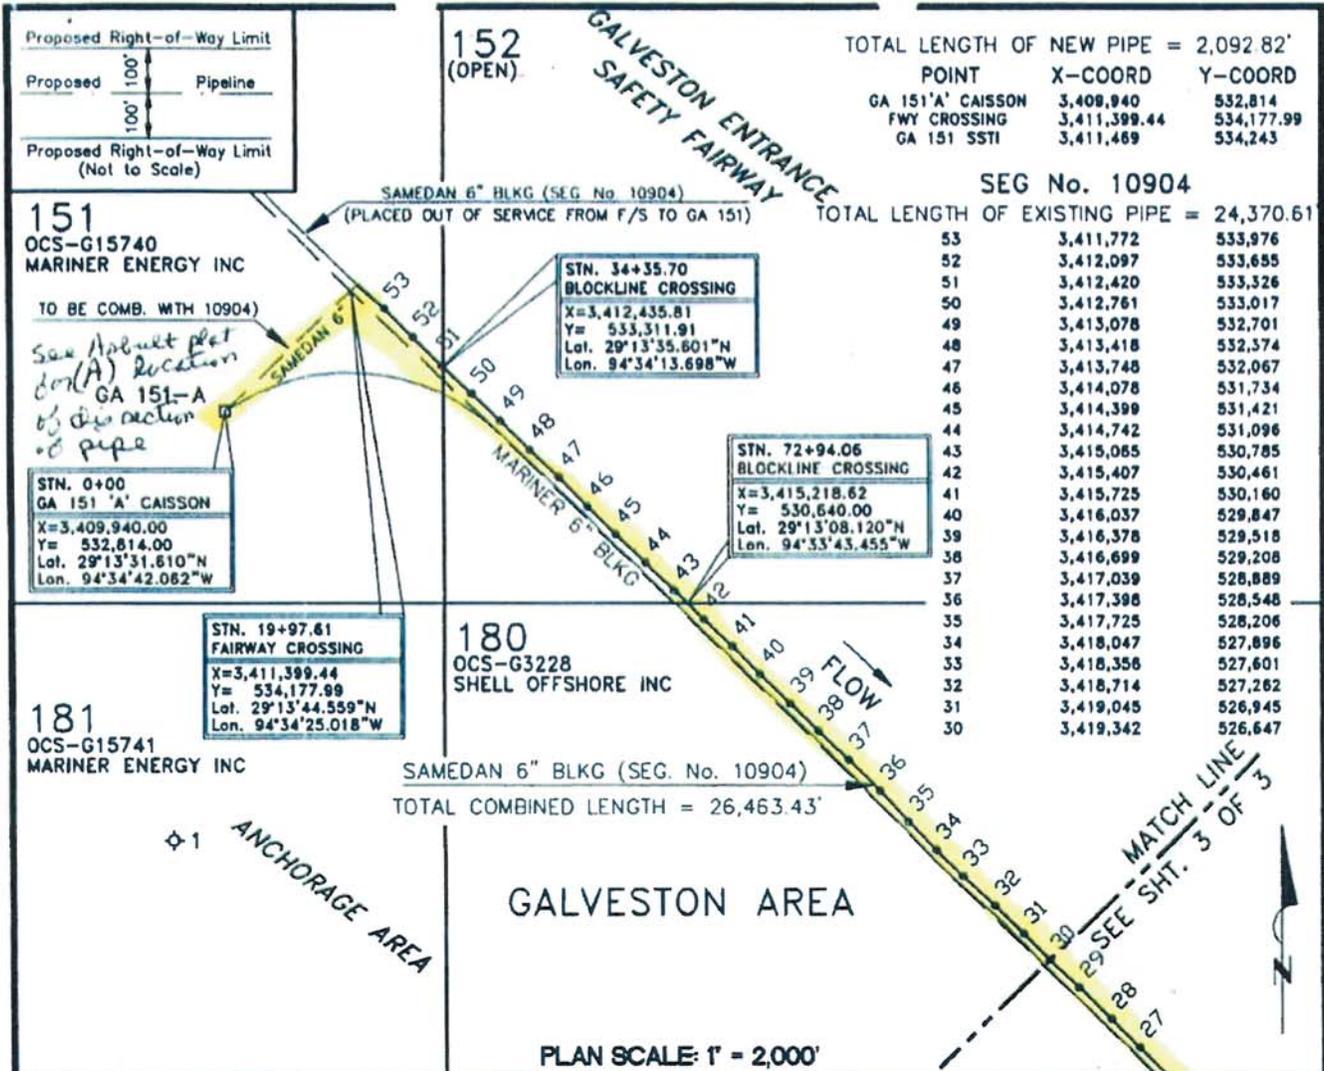

I HEREBY CERTIFY THE ABOVE PROPOSED PIPELINE LOCATION IS CORRECT.


Terry C. Schultz Tex. Reg. No. 5161
 8-5-99

DATUM: NAD 27
SPHEROID: CLARKE 1866
PROJECTION: LAMBERT
ZONE: TEXAS SOUTH CENTRAL

Racal NCS, Inc.
 3624 Westchase Drive
 Houston, Texas 77042
 Tel 713-784-4482 Fax: 713-784-8162

SAMEDAN OIL CORPORATION
 PART OF AS-BUILT JAN 31804
 PROPOSED 6" BLKG PIPELINE
 GA 151 "A" CAISSON TO HI 179 'A' PLAT.
GALVESTON AREA TO HIGH ISLAND AREA
 SHEET 2 OF 3

DATE 08/02/99	DRAWN BY: VJA	CHECKED BY: DHL	DRAWING No. PER13378
REV. DATE -----	REV. No.: 00	SCALE: AS-SHOWN	JOB No. 1795 DP No. 3378

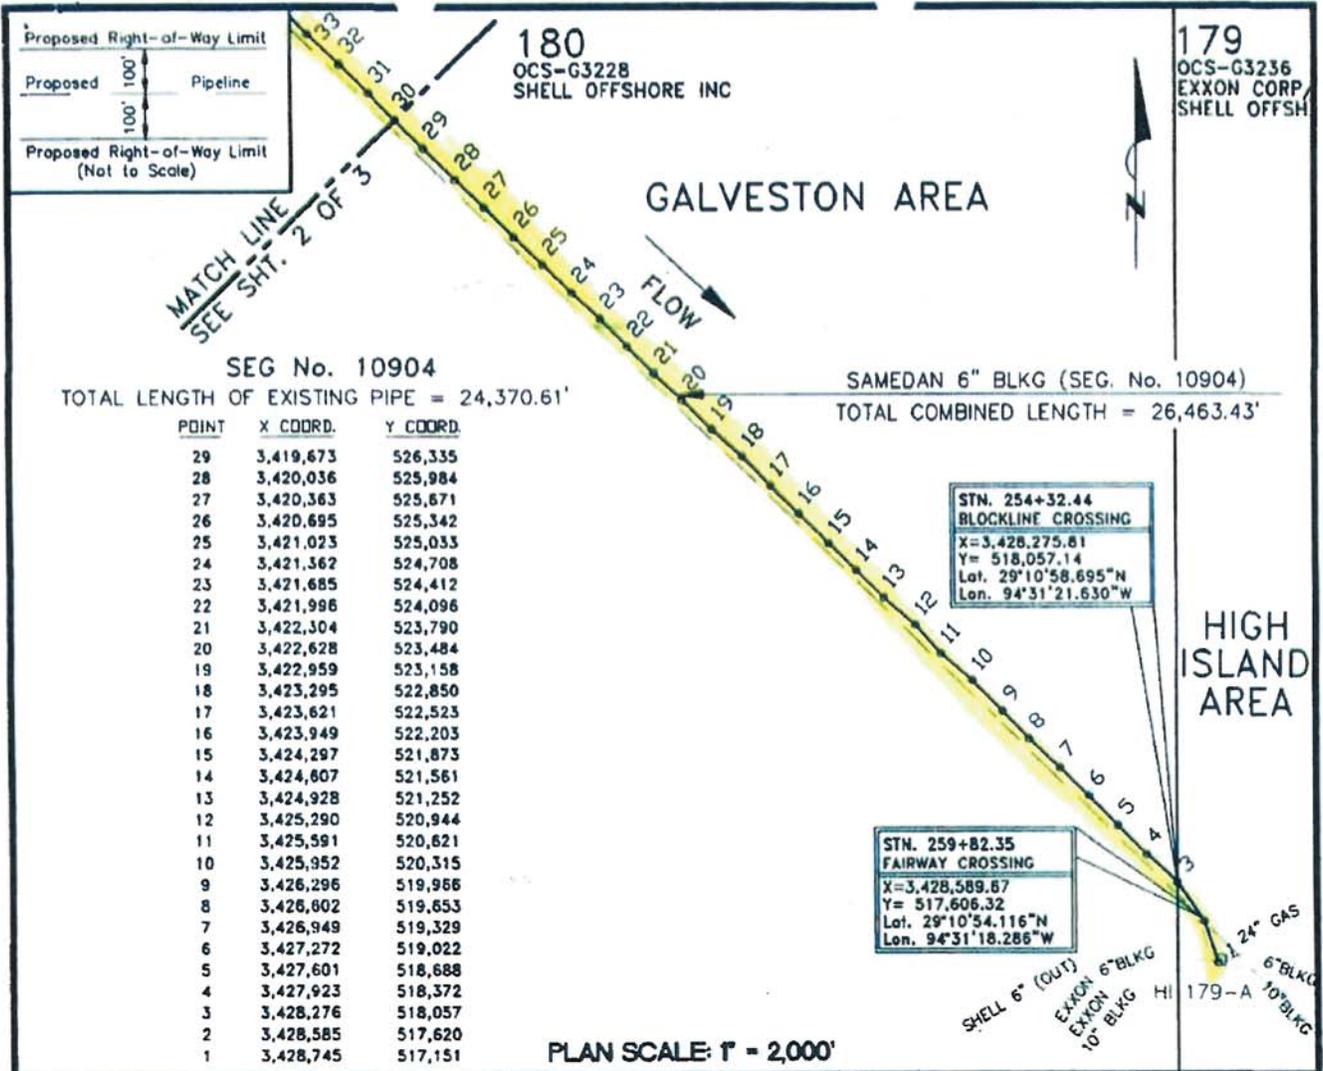

SEG No. 10904
TOTAL LENGTH OF EXISTING PIPE = 24,370.61'


SAMEDAN 6" BLKG (SEG. No. 10904)
TOTAL COMBINED LENGTH = 26,463.43'

POINT	X COORD.	Y COORD.
29	3,419,673	526,335
28	3,420,036	525,984
27	3,420,363	525,671
26	3,420,695	525,342
25	3,421,023	525,033
24	3,421,362	524,708
23	3,421,685	524,412
22	3,421,996	524,096
21	3,422,304	523,790
20	3,422,628	523,484
19	3,422,959	523,158
18	3,423,295	522,850
17	3,423,621	522,523
16	3,423,949	522,203
15	3,424,297	521,873
14	3,424,607	521,561
13	3,424,928	521,252
12	3,425,290	520,944
11	3,425,591	520,621
10	3,425,952	520,315
9	3,426,296	519,966
8	3,426,602	519,653
7	3,426,949	519,329
6	3,427,272	519,022
5	3,427,601	518,688
4	3,427,923	518,372
3	3,428,276	518,057
2	3,428,585	517,620
1	3,428,745	517,151

STN. 254+32.44
BLOCKLINE CROSSING
X=3,428,275.61
Y= 518,057.14
Lat. 29°10'58.695"N
Lon. 94°31'21.630"W

STN. 259+82.35
FAIRWAY CROSSING
X=3,428,589.67
Y= 517,606.32
Lat. 29°10'54.116"N
Lon. 94°31'18.286"W

PLAN SCALE: 1" = 2,000'

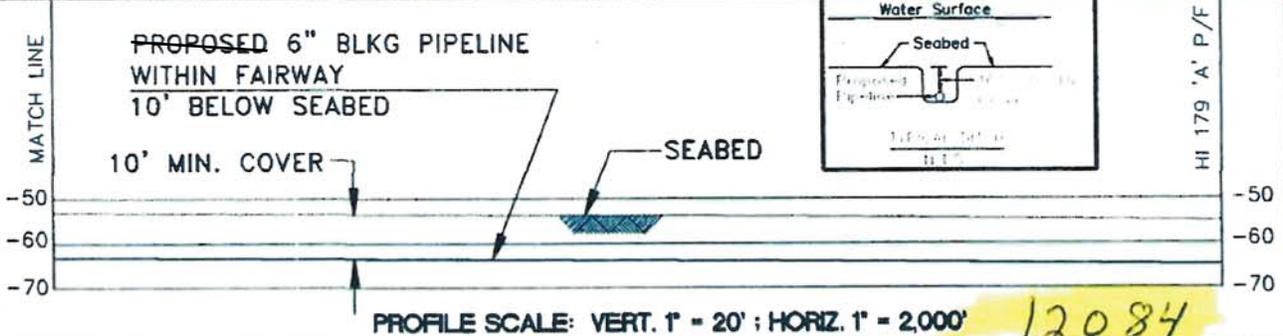

PROFILE SCALE: VERT. 1" = 20' ; HORIZ. 1" = 2,000'

I HEREBY CERTIFY THE ABOVE PROPOSED PIPELINE LOCATION IS CORRECT.

Terry C. Schultz
Terry C. Schultz Tex. Reg. No. 3161
8-2-99
Date

DATUM: NAD 27
SPHEROID: CLARKE 1866
PROJECTION: LAMBERT
ZONE: TEXAS SOUTH CENTRAL

Racal NCS, Inc.
3624 Westchase Drive
Houston, Texas 77042
Tel: 713-784-4482 Fax: 713-784-8162



SAMEDAN OIL CORPORATION
PART OF AS-BUILT
PROPOSED 6" BLKG PIPELINE
GA 151 "A" CAISSON TO HI 179 'A' PLAT.
GALVESTON AREA TO HIGH ISLAND AREA
SHEET 3 OF 3

DATE 08/02/99	DRAWN BY: VJA	CHECKED BY: DHL	DRAWING No. PER23378
REV. DATE -----	REV. No.: 00	SCALE: AS-SHOWN	JOB No. 1795 DP No. 3378

